

EQUI	PMENT LEGEND				
ITEM #	DESCRIPTION		DETAIL #	DWG #	
1.	DENTAL UNIT	ADEC CASCADE 2132 EURO UNIT W/TOUCH PAD	JB	4 OF 5	120 V. , 4AMPS
2.	DENTAL UNIT	BEAVERSTATE CABINET MOUNTED VACUUM UNIT	DC	4 OF 5	—
3.	DENTAL LIGHT	DCI EDGE SERIES 4 LED CEILING MOUNTED LIGHT 9'-6" COLUMN	CL	4 OF 5	120 V. , 1 AMPS
4.	X-RAY	CORIX 70 PLUS WM-USV CABINET MOUNTED X-RAY 71" REACH	DC2	4 OF 5	120 V., 10 AMPS
5.	X-RAY CONTROL	CORIX 70 PLUS WM-USV -X-RAY CONTROL	DC	4 OF 5	
6	MASTER PANEL	TECHWEST CP-1V1A REMOTE CONTROL PANEL	V	5 OF 5	
7.	COMPRESSOR	DENTAL PLANET SMART AIR 320 COMPRESSOR W/ COVER COMPRESSOR	С	5 OF 5	220 V. , 8.6AMPS
8.	VACUUM UNIT	TECHWEST VPD2S2 ECOVAC DRY VACUUM UNIT	V	5 OF 5	220 V. , 12AMPS
9.	AMALGAM SEP.		V	5 OF 5	220 V., 12/4WII O
10.	DENTAL CHAIR	SLOMETEX AMALGAM SEPARATOR ADEC 1040 DENTAL CHAIR		+	120 V. , 8AMPS
11.	DOCTOR'S STOOL	LINK 185AB DOCTOR'S STOOL 2			120 V., 0AIVIF3
12.	ASSIST'S STOOL	GALAXY 1067R ASST'S STOOL			
13.	AUTOCLAVE	TUTTENHAUER EZ10 AUTOCLAVE			120 V., 20AMPS
14.	AUTOCLAVE	SCICAN STATIM 5000 AUTOCLAVE			1450W V. , 120 V
15.	ULTRASONIC CLNR	BRANDIMAX U-10LH ULTRASONIC CLNR.10			
16.	N2020 UNIT	BELMED FLOWMETER W/4 CYLINDER YOKE			
		AND TALL MOBILE STAND MODEL #50144,			
		CYLINDER YOKE			
17.	STEAM CLEANER	RELIABLE STEAM CLEANER 5000 CJ			1000W., 8AMPS
18.	HANDPIECE CLEANER	TPC H6000 HANDPIECE CLEANER			
	LAB				
19.	PLASTER TRAP	BUFFALO 62100 PLASTER TRAP	PT	4 OF 5	<u> </u>
20	MODEL TRIMMER	HANDLER 31 MODELTRIMMER	PT	4 OF 5	115 VOLT, 1/3 HP
21.	LATHE	LATHE			115 VOLT, 1/4 HP
	CABINETS				
A	DENTAL CABINET	REAR TREATMENT CONSOLE			
B	DENTAL CABINET	CENTER ISLAND CABINET DOCTOR'S SIDE COUNTER			1
C	DENTAL CABINET DENTAL CABINET	ASST'S SIDE CABINET			
D E	DENTAL CABINET DENTAL CABINET	STERILIZATION CABINET		-	+
F	DENTAL CABINET	LAB CABINET			
	DENTIAL ORDINE!				
. — — — —					


THIS SYMBOL REPRESENTS FUTURE DENTAL EQUIPMENT THIS SYMBOL REPRESENTS NEW DENTAL EQUIPMENT BEING SUPPLIED BY DENTAL PLANET .COM THIS SYMBOL REPRESENTS EXISTING/ DENTAL EQUIPMENT OR DENTAL PLANET THAT IS NOT NOT BEING SUPPLIED BY DENTAL PLANET

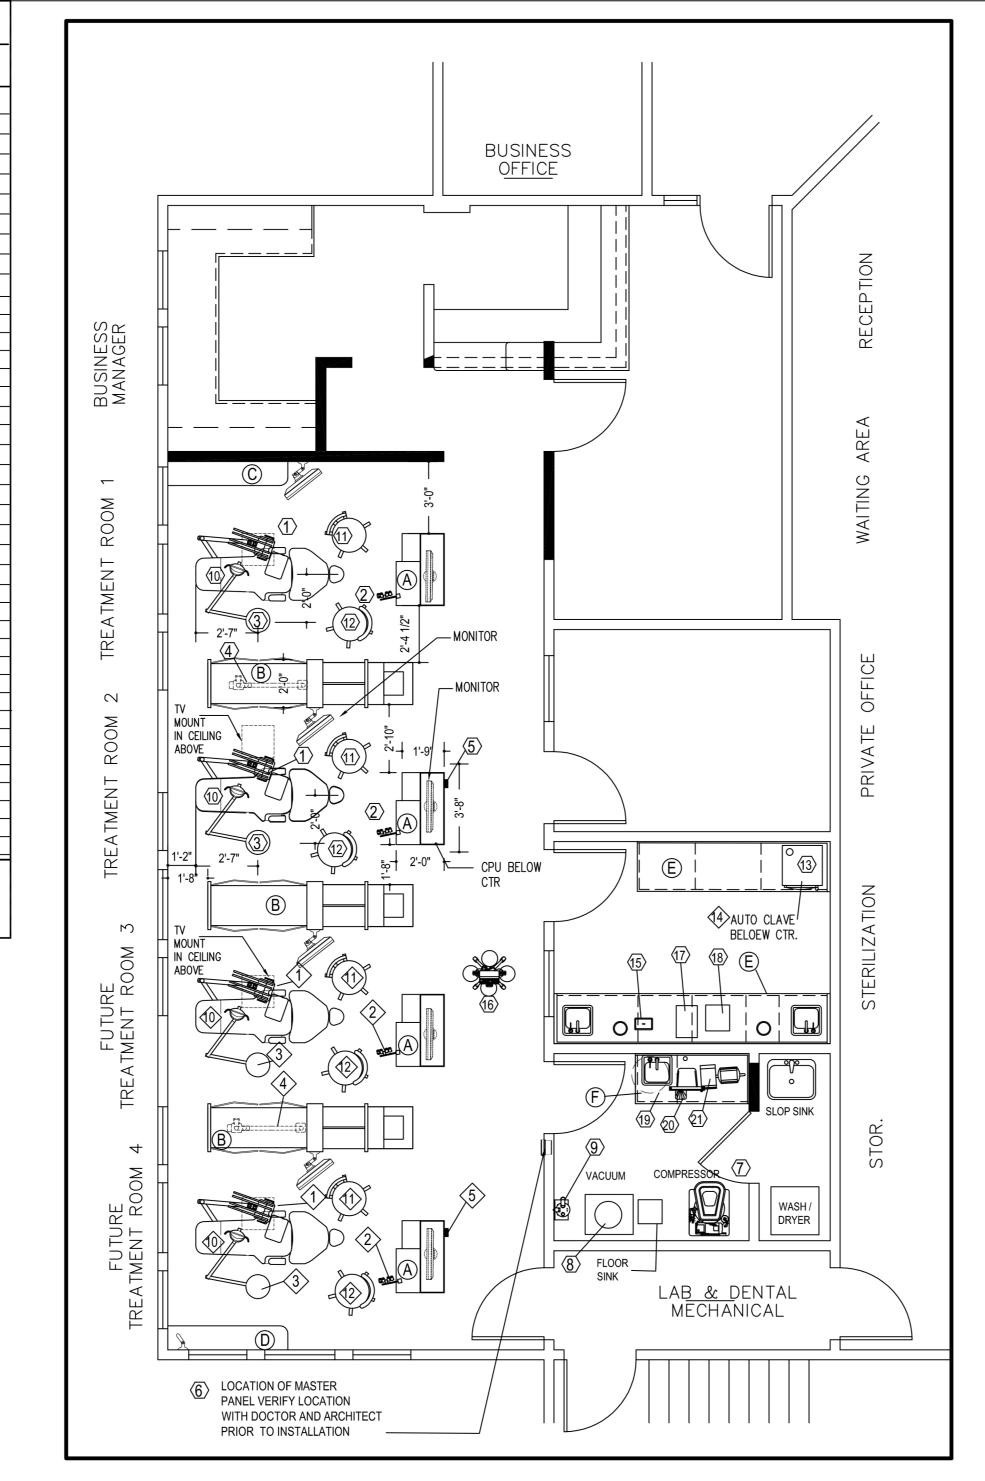

EQUIPMENT PLAN - SCALE 1/4"=1'-0"

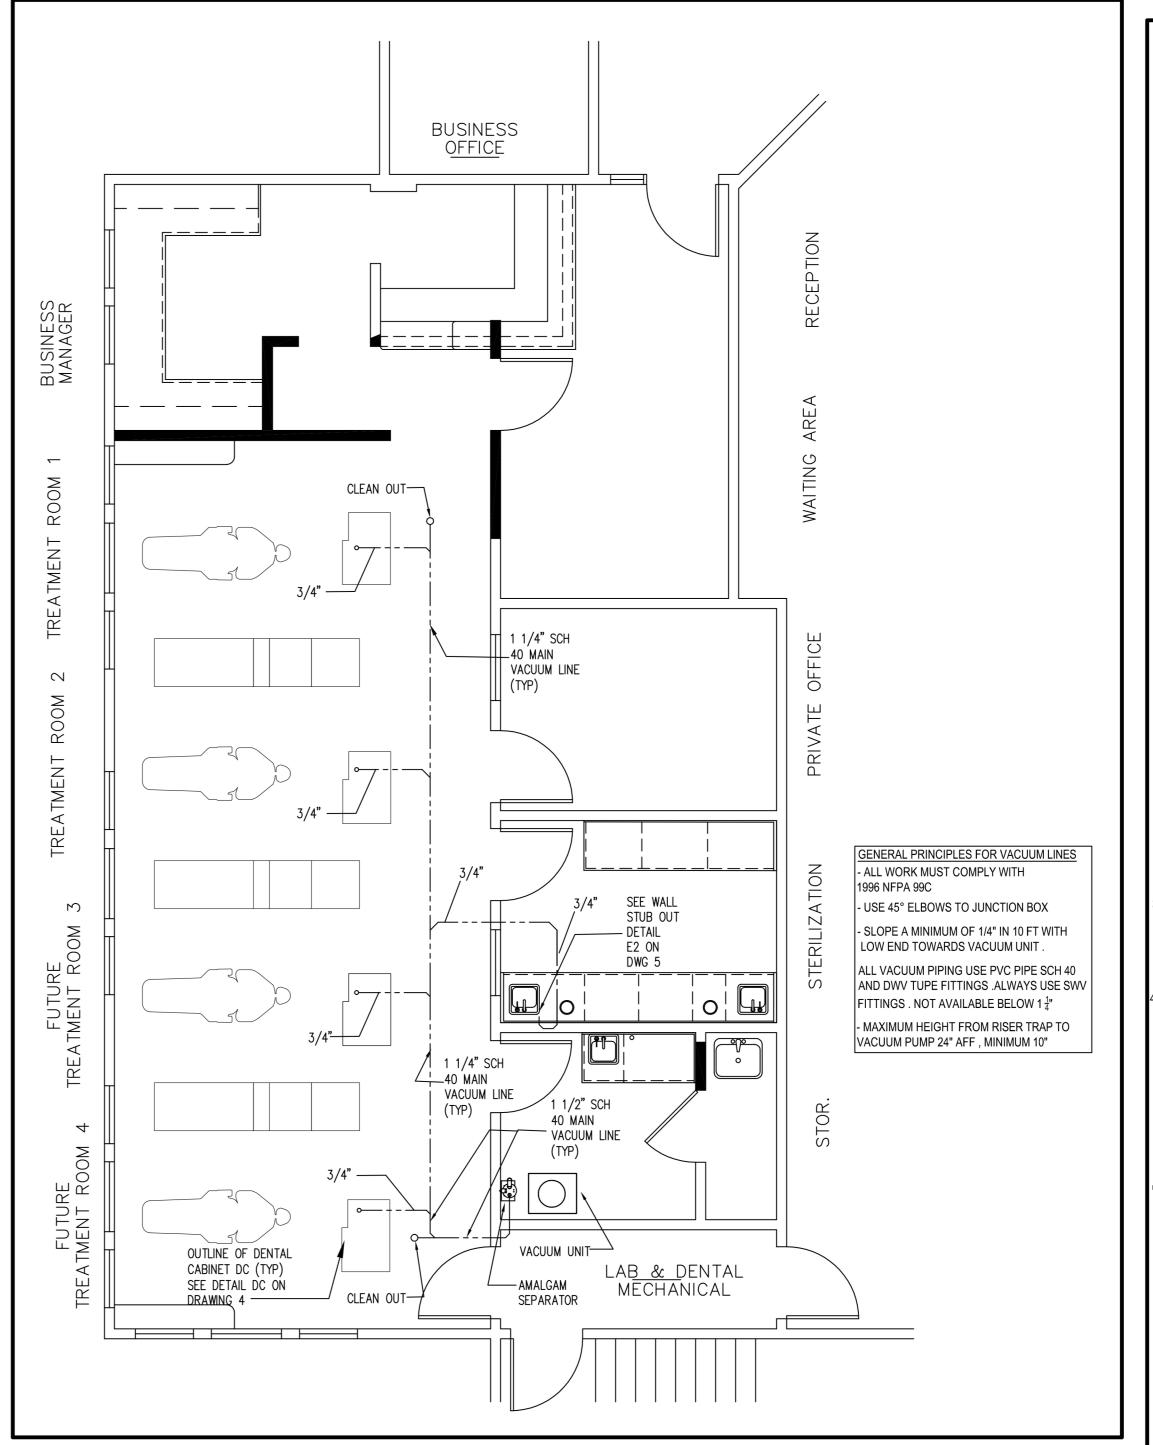

VACUUM PIPING PLAN - SCALE 1/4"=1'-0"

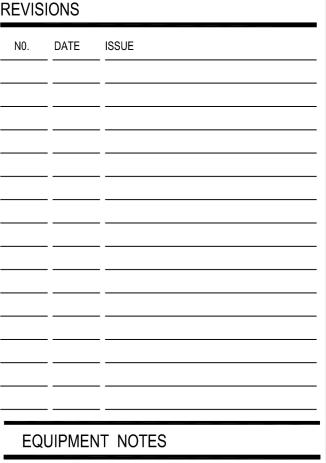

1.EQUIPMENT PLAN TO BE USED PRIMARILY BY DENTAL

2. DENTAL INSTALLER TO INSTALL X-RAY PUSH BUTTON ON CORRIDOR SIDE OF CABINET "A"

CONSTRUCTION NOTES

- GC TO READ ALL CARPENTRY, PLUMBIING DEMOLITION AND ELECTRICAL GENERAL NOTES ON DRAWING N0.1 GC TO SEE ARCHITECT'S DRAWINGS CONCERNING THE SPECIFICATIONS AND LOCATIONS OF ALL PARTITIONS.
- GC SHALL NOT INSTALL BOTH SIDES OF GYP. BD. ON THOSE PARTITIONS WHICH WILL PREVENT THE INSTALLATION OF LOW VOLTAGE CABLING FOR IT **EQUIPMENT COORDINATE INSTALLATION OF CABLING WITH**
- UPPER CABINETRY SUPPORTS ON EXISTING WALLS (AS AN OPTION) CAN BE BE SURFACE MOUNTED .GC TO COORD-INATE THE EXACT LOCATION AND TYPE OF SUPPORT WITH CABINET CONTRACTOR.GC TO SEE ARCHITECTS PLANS FO THE LOCATIONS OF ALL WALL HUNG CABINETRY SUPPORT IN NEW WALLS
- SEE ARCHITECTS PLANS FOR LOCATIONS AND SPECIFIC -ATIONS OF ALL ELECTRICAL OUTLETSDATA, VIDEO OUT-LETS AND PLUMBING ROUGHING IN NON CLINICAL AREAS: WAITING ROOM, BUSINESS OFFICE, PRIVATE OFFICE, MANAGER'S OFFICE AND RECEPTION AREA.



GC TO CHECK ALL LOCAL CODES FOR COM-PLIANCE. BECAUSE OF VARYING CITY CODES, DENTALPLANET.COM CANNOT BE HELD RESPONSIBLE FOR AN INSTALLATION WHICH DOES NOT MEET LOCAL PLUMBING AND ELECTRICAL CODE.

DRAWINGS ARE FOR ARCHITECT'S USE



Tel #: 1-877-964-2377 940- 257-2733 Fax #: 940-322-8220

THE ABOVE DESIGNS, PLANS, AND SPECIFICATIONS ARE THE PROPERTY OF DentalPlanet .com. THE CONTR- ACTOR IS RESPONSIBLE FOR CHECKING ALL DIMENSIONS AND CONDITIONS AT THE JOB SITE, AS BUILDING RULES. CON-TRACTOR SHALL NOTIFY DentalPlanet .com. OF ANY SIGNIFICANT DISCREPENCIES BETWEEN SITE CONDITIONS AND CON-STRUCTION DOCUMENTS PRIOR TO THE COMMENCEMENT OF CON- STRUCTION. CONTRACTOR IS RESPONSIBLE FOR INSURING THAT ALL TRADES ARE PRESENT ON THE SCHEDULED DAY OF INSTALLATION OF DENTAL EQUIPMENT. UNAUTHORIZED USE OF THESE PLANS WITHOUT THE CONSENT OF DentalPlanet .com. IS UNLAWFUL.

AS NOTED AS NOTED 2 OF 5